


幹線市道 I -3号線舗装補修工事 (7-1)

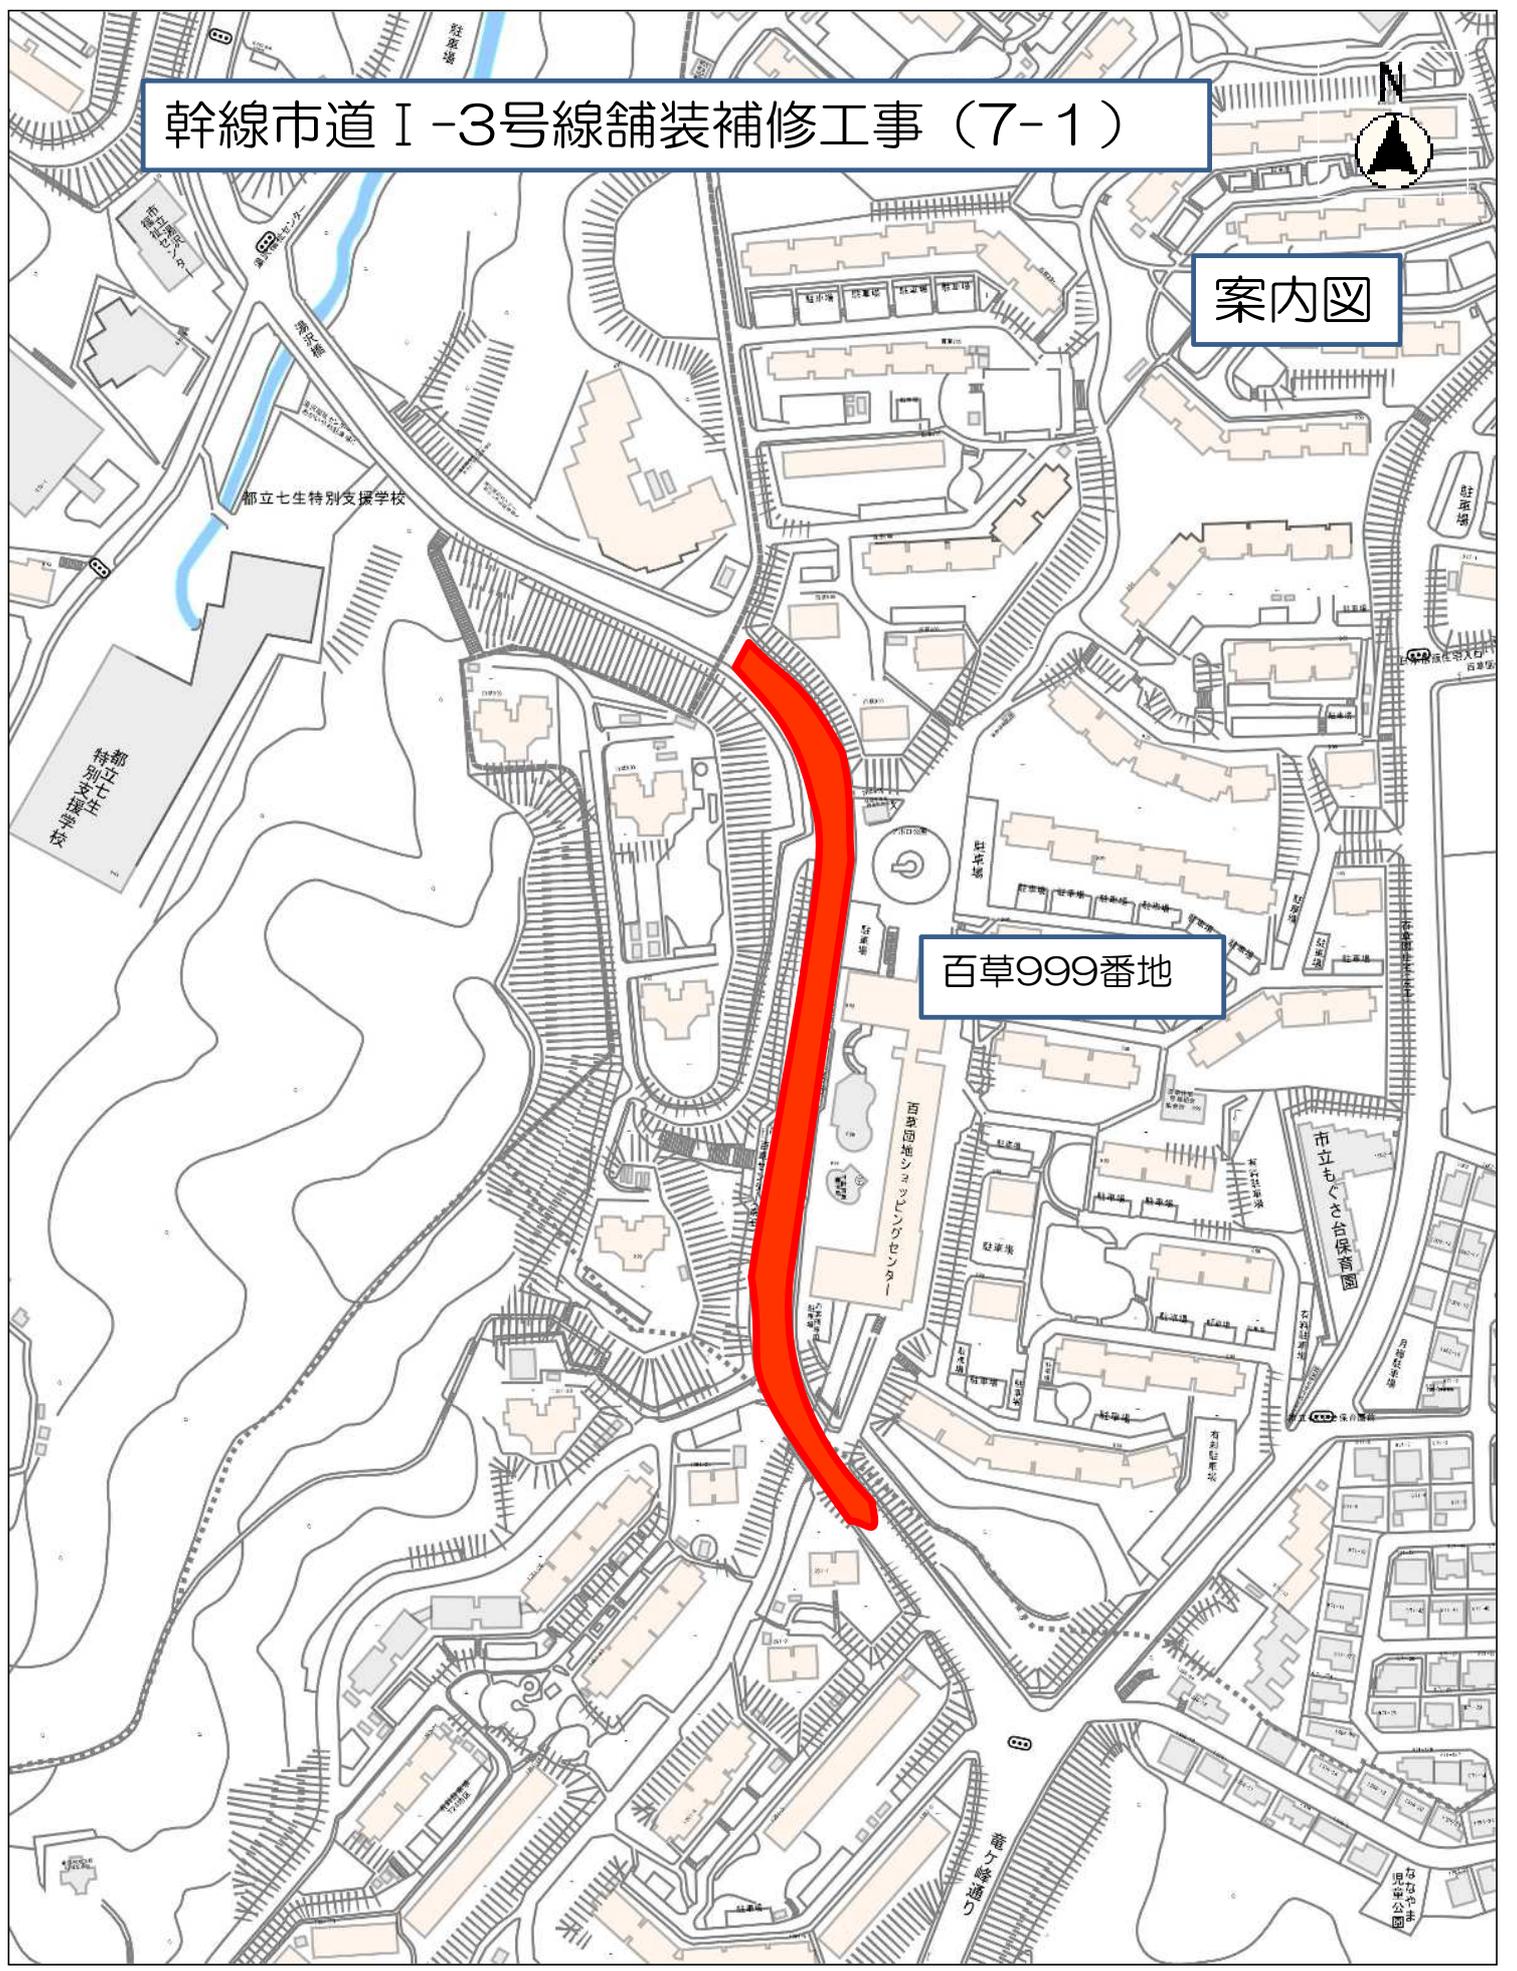

案内図



百草999番地

縮尺 1 : 2500

